


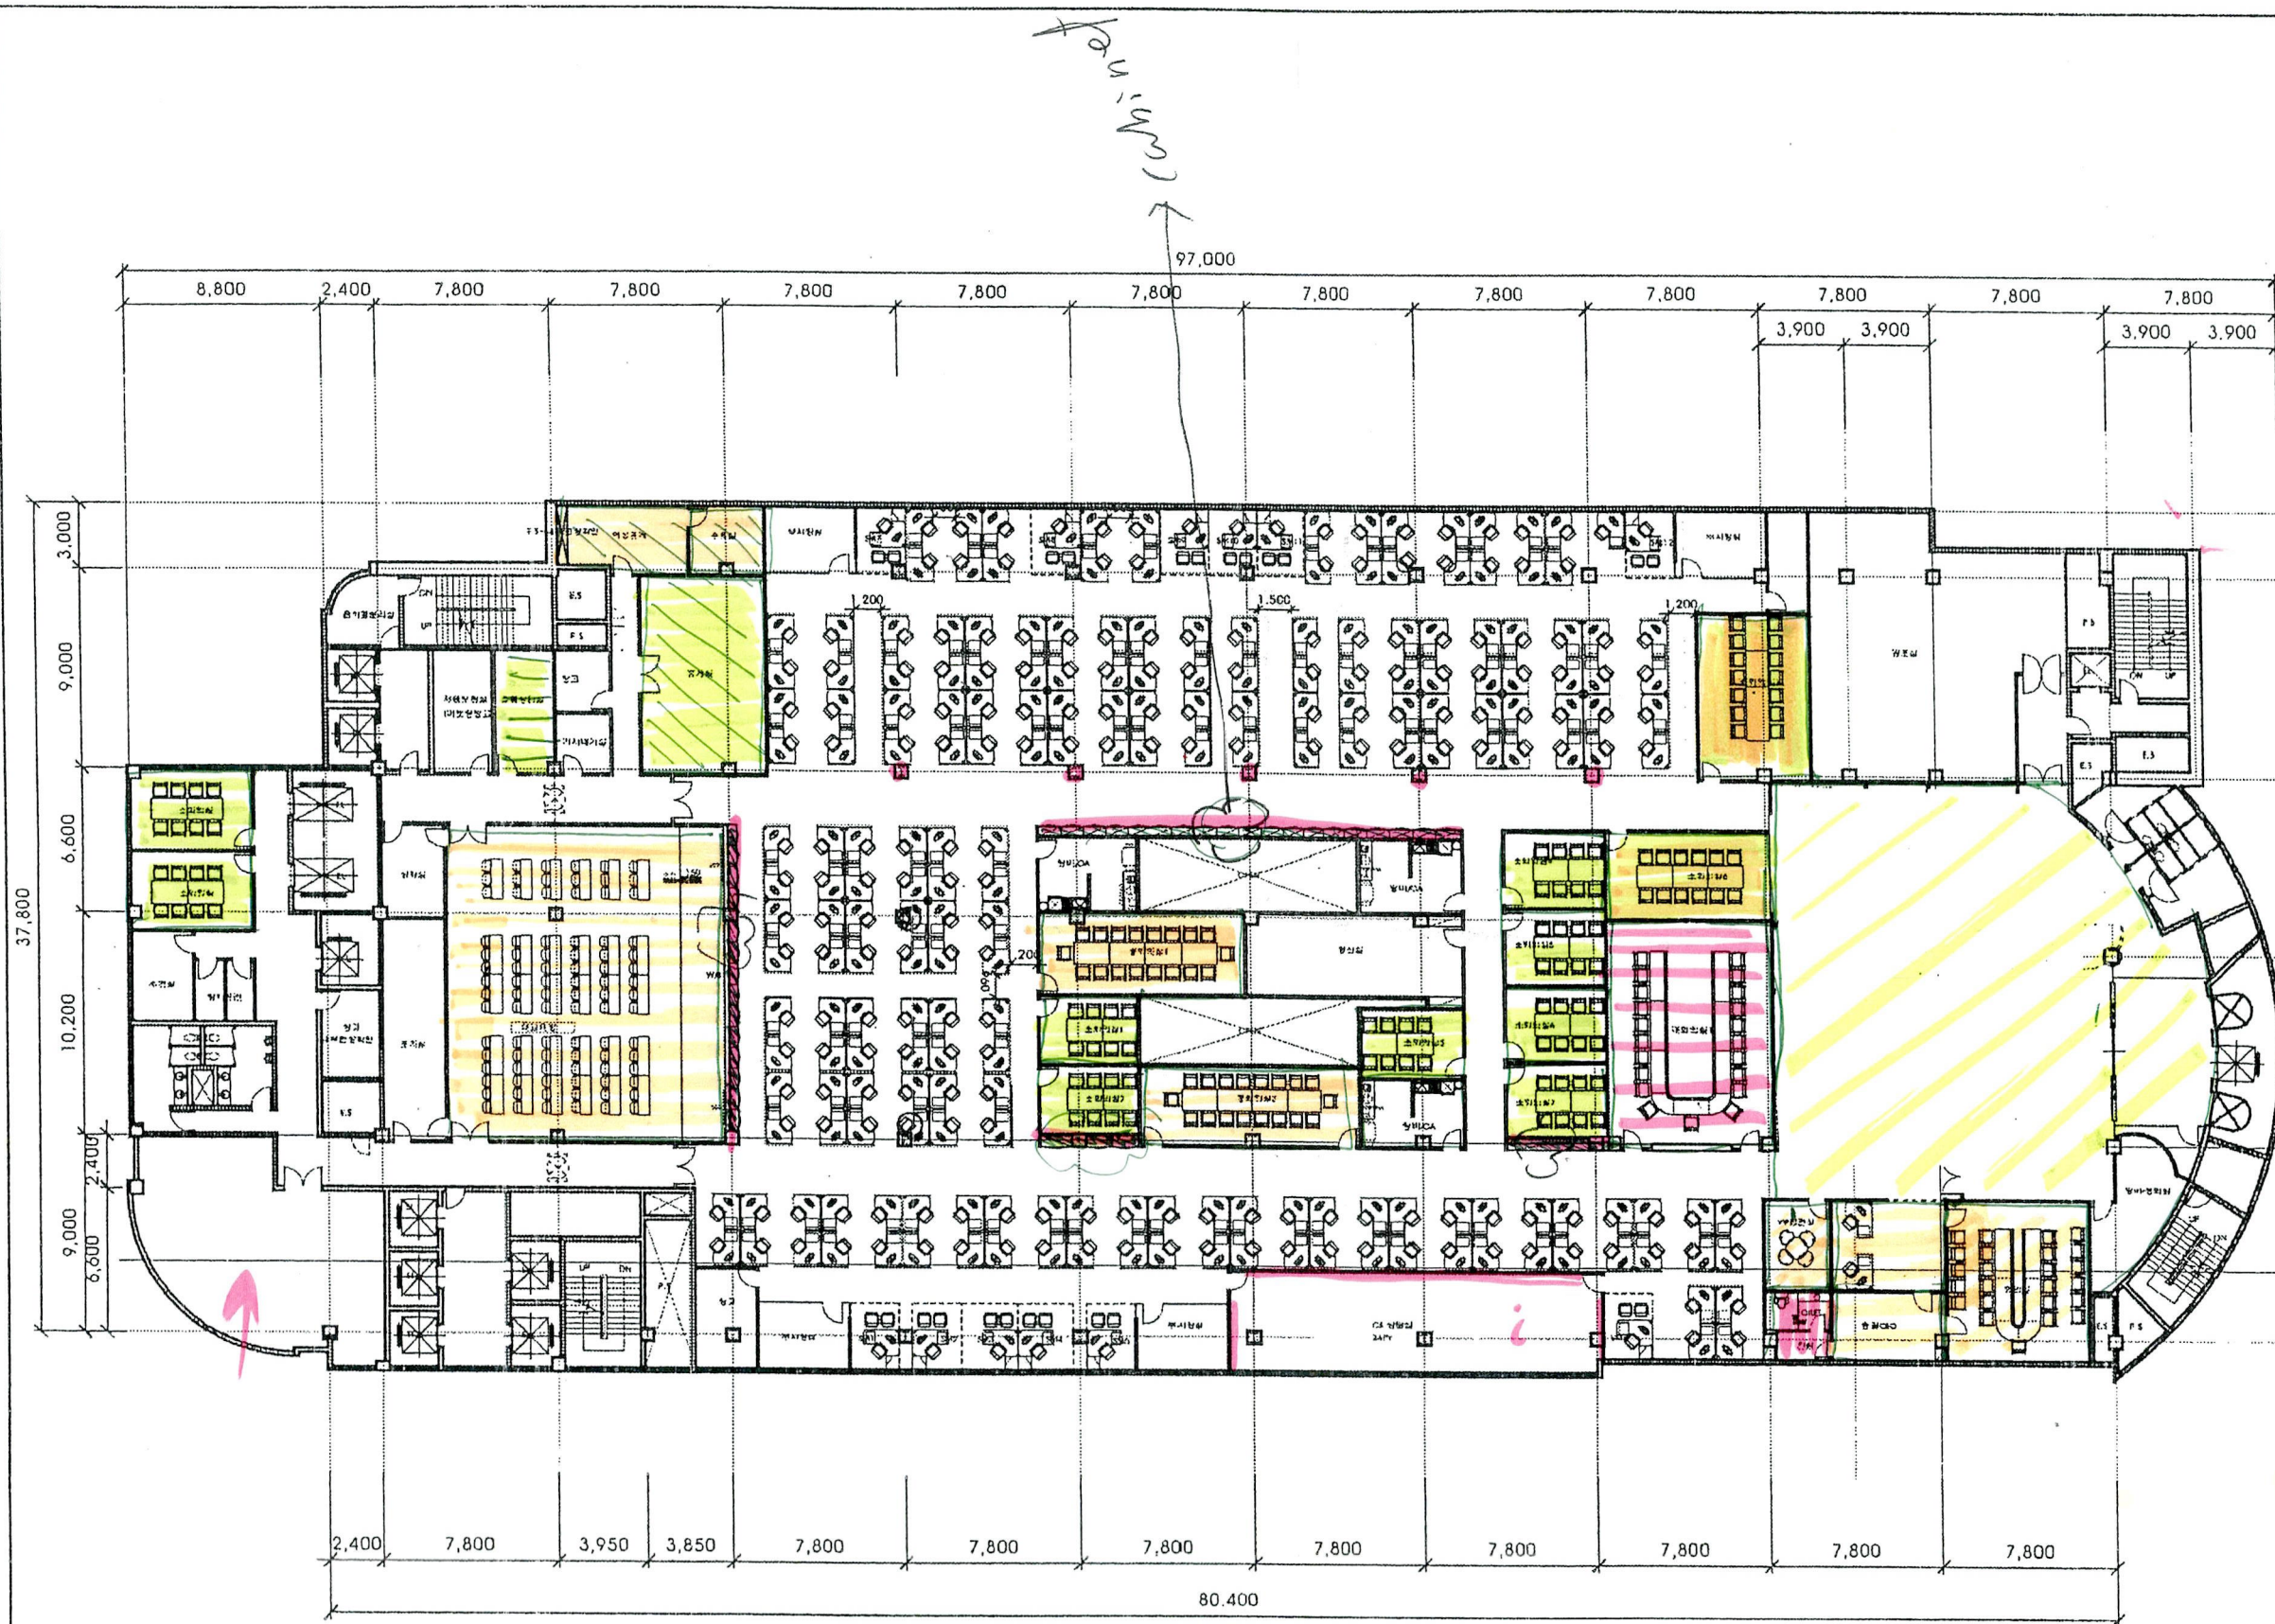

PROJECT TITLE
PULMUONE 본사
사무실 이전 공사
8th FLOOR PLAN

NOTE

REVISION

NO.	DESCRIPTION	DATE	APP.
7			
6			
5		3/5	
4		2/28	
3		2/23	
2		2/10	
1		1/8	

DRAWING BY
CHECKED P.J.Y
DATE 2008. 7.
SCALE
NAME OF DRAWING
FLOOR PLAN
DRAWING NO. I-101
SHEET NO. 01

EHYUN
DESIGN GROUP
Interior Architecture • Display • Furniture
31, POEUN Bldg. 21st Fl. 4 Nonhyun - dorp.
Gangnam-gu, SEOUL, KOREA
TEL : +82 2-540.8883
FAX : +82 2-540.1467
http://www.ehyun.co.kr